


NO.	ROAD NAME	LGTH.	LOG.
1001	WARDS BRANCH	2.7	C1
1002A	QUIRE'S RUN	2.9	A3
1002B	PARKVILLE CROSS PIKE	3.1	B3
1004	MACKVILLE	2.6	A2
1005	GENTRY LANE	2.0	A4
1006	DUNCAN HILL	1.5	B4
1007	BUSTER	2.6	A4
1008	BRADLEY	2.2	A5
1009A	PERRYVILLE-MITCHELLSBURG	3.9	B2
1009B	SCRUBGRASS	5.8	C2
1010A	WHITE OAK	3.5	C4
1010B	BERGER KNOB	2.4	C3
1012	BOND	0.5	A2
1013A	HARBERSON LANE	3.5	B2
1013B	JOHNSON BRANCH	2.9	C3
1014A	CROSSROAD	1.0	B4
1014B	HOGUE HOLLOW	2.5	B4
1015A	NORTH CRANETOWN	3.2	A1
1015B	COUTH CRANETOWN	3.2	B1
1016A	WHITE	4.2	B1
1016B	SHORT LINE AND WHITE	2.0	B1
1017	BULL LANE	2.0	B2
1018A	WATER WORKS	2.5	A5
1018B	DONNAHUE-GOGGINS	2.6	B5
1019	KING'S MILL	1.0	A5
1020A	POKE	2.1	B5
1020B	COOK LIPPS	4.1	B5
1021A	POOR HOUSE	0.7	B1
1021B	CRAINS SCHOOL	0.7	B1
1022	MINORS BRANCH	1.4	C2
1023	NICK FORD	1.4	C2
1024	TAR LICK	1.4	C2
1025	LAKE POND	2.1	C3
1026	PHILLIPS	0.7	C4
1027	CASH	0.9	B3
1028	BONTA	2.0	B4
1029	UNION AND HOPE	2.7	B2
1030	CARPENTERS FORK	1.1	C3
1031	BLUE GRASS	5.5	A4
1032A	HARMON	1.8	A3
1032B	GODBY	1.3	B3
1032C	MITCHELL	1.5	B2
1034	GOSE	2.8	B4
1035	BAUGHMAN HGTS.	1.1	B5
1036A	GRUBS LANE	0.4	C4
1036B	GRUBS LANE SPUR	0.2	C4
1039A	LOCKLIN	1.5	B3
1039B	CALDWELL	2.1	B3
1039C	TARKINGTON-IRVIN	1.2	B3
1039D	UPPER SALT RIVER	1.1	B3
1039E	PUMPKIN RUN	1.5	C3
1039F	CREAM RIDGE	1.6	C3
1041	PREWITT	0.3	B2
1042	STEWART'S LANE	4.1	B4
1043	FAULKNER	2.8	A4
1045A	OSCAR BRADLEY	1.5	A2
1045B	HAYS-MAY	2.0	A2
1046	WEBSTER	5.0	B3
1048	SALT RIVER	1.6	B3
1049	SALT LICK CHURCH	1.3	A3
1051	GWINS ISLAND	0.8	A4
1052	CLIFTON	2.2	B5
1054	OLD MITCHELLSBURG	1.4	B3
1057	MILL CREEK	1.1	C1
1060	CLK CAVE	0.7	C2
1061	GUYN ISLAND	0.4	A4
1062	CLAUNCH	1.5	A2
1063A	TUGGLE	1.5	B3
1063B	QUARRY	1.9	B3
1064	NIELD	1.5	A3
1066	REED	1.2	A3
1069	TENNESSEE RIDGE	2.0	C3
1070	PERSIMMON	1.7	B3
1072	NOSCO	1.8	C3
1074	KNOB LICK	2.9	C3
1075	RANKIN	0.7	B6
1076	CEMETERY	0.5	C4
1078	PERRYVILLE SCHOOL	0.5	B2
1079	SPEARS	1.1	A4
1080	ALICETON	1.0	B1
1081	HUGHES LANE	0.9	B4
1082	ALDRIDGE LANE	0.3	B4
1083	SOUTH 2ND STREET	0.5	D4
1084	SIMPSON LANE	0.3	B4
1085	2ND STREET-BAUGHMAN HGTS.	0.4	B4
1086	HOPPERS HGTS.	0.3	B2
1087	MARVIN GIBSON	0.2	B1
1088	GOBLEY	1.4	C2
1089	ROLLINS	0.9	C2

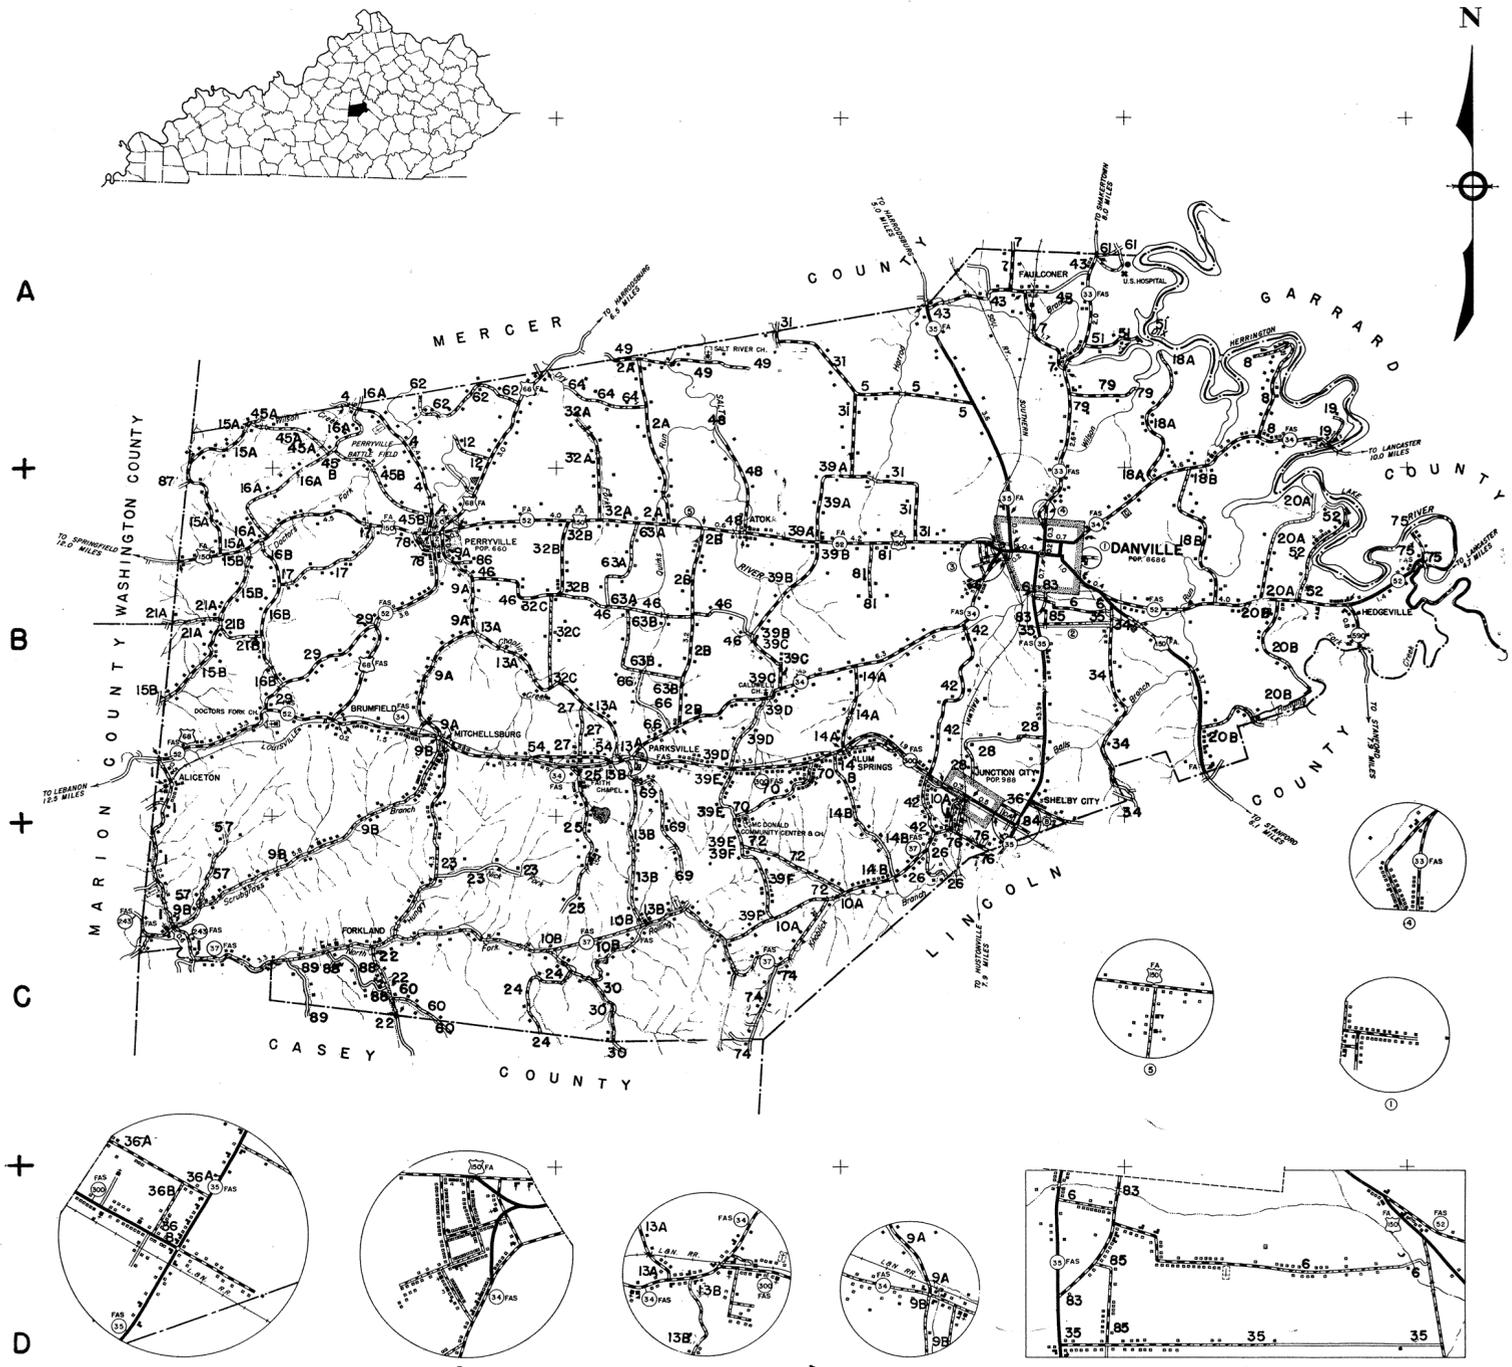

1952 RURAL HIGHWAY SERIES

BOYLE COUNTY KENTUCKY

PREPARED BY THE
KENTUCKY DEPARTMENT OF HIGHWAYS
IN COOPERATION WITH THE
FEDERAL WORKS AGENCY
PUBLIC ROADS ADMINISTRATION
DATA OBTAINED FROM
STATE-WIDE HIGHWAY PLANNING SURVEY

SCALE 1:25000
ENLARGEMENT SCALE
1941

REVISIONS
SUB-TYPE I-L-50
POPULATION 1950
SUB-TYPE I-L-51

POLYCONIC PROJECTION

LEGEND

<ul style="list-style-type: none"> UNITED STATES HIGHWAY STATE HIGHWAY SYSTEM STATE BOUNDARY COUNTY BOUNDARY CORPORATE LIMITS NATIONAL FOREST, STATE PARK WATERWAYS WIDE STREAMS IMMOVABLE STREAMS HEAD OF NAVIGATION (LARGE STREAMS) GRASSY DITCH FREE FERRY TOLL FERRY HIGHWAY TUNNEL LEVEL WITH ROAD FORD COUNTY SEAT OTHER CITIES & VILLAGES PROMINENT ELEVATIONS AIR ROUTES RAILROAD RAILROAD BRIDGE DAM WITH LOCK SMALL DAM WITH LOCK LARGE RESERVOIR, POND OR LAKE 	<ul style="list-style-type: none"> MONUMENT SMALL GOLF COURSE OR COUNTRY CLUB SMALL PARKS FAIR GROUNDS, RACE COURSES, SPEEDWAYS CEMETERY CHURCH WITH CEMETERY ADJACENT IN USE NOT IN USE FARM UNIT DWELLINGS (OTHER THAN FARM) RODS OR GROUPS OF DWELLINGS CLOSELY SPACED STORE OR SMALL BUSINESS ESTABLISHMENT HOTEL CHURCH, OTHER RELIGIOUS INSTITUTIONS SCHOOL, HOUSE, OTHER EDUCATIONAL INSTITUTIONS HOSPITALS FACTORY OR INDUSTRIAL PLANT SEASONAL OR SUMMER COLONY DWELLINGS SEASONAL DWELLINGS CLOSELY SPACED CCC CAMP AIRWAY BEACON LIGHT ARMY, NAVY, OR MARINE CORPS FIELD DEPARTMENT OF COMMERCE INTERMEDIATE FIELD CORPORAL OR MUNICIPAL FIELD MARKED AUXILIARY FIELD AIRPORT HOUSING FACILITIES AIRPLANE LANDING FIELD MARKED OR EMERGENCY 	<ul style="list-style-type: none"> SAWMILL (STATIONARY) QUARRY OR GRAVEL PIT WINE OIL OR GAS WELLS TANKS POWER PLANT TOWNHALL, GRANGE OR COMMUNITY HALL FOREST SERVICE LOGGING STATION GAUGING OR PUMPING STATION MUNICIPAL GARAGE OR RUBBISH DUMPS STATE ROAD GARAGES SEASONAL INDUSTRY (CANNERY OR SMALL GRAIN MILL) FRESH AIR FARMS OR REST HOMES COUNTY FARM CORRECTIONAL INSTITUTION RADIO STATION CAMP GROUND TOURIST CAMP MUNICIPAL PARK PLAYGROUNDS, BALL FIELDS ETC. BATHING BEACHES GENERIC SITES GAME FARMS GAME PRESERVES RAILROAD (ANY NUMBER TRACKS) USED BY SINGLE OPERATING COMPANY RAILROAD STATION RAILROAD GRADE CROSSING RAILROAD ABOVE 	<ul style="list-style-type: none"> RAILROAD BELOW RAILROAD TUNNEL <p style="text-align: center;">ROAD TYPES</p> <ul style="list-style-type: none"> TRAIL PRIMITIVE ROAD UNIMPROVED ROAD GRADE AND DRAINED ROAD SOIL SURFACE ROAD (WASTE) METAL SURFACE ROAD LOW TYPE BITUMINOUS ROAD PAVED ROAD WIDEWAY INDICATED
--	--	---	--